


NUPI PIPE LEGEND

-  NUPI - SW POLY DISP SUMP- WAYNE 3+1 (4)
-  NUPI - SW POLY DISP SUMP- WAYNE 3+0 (2)
-  NUPI - SW POLY DISP SUMP- WAYNE M/MS/S (3)
-  NUPI - 2.00" DW FUEL PIPE - REGULAR LINE
-  NUPI - 2.00" DW FUEL PIPE - PREMIUM LINE
-  NUPI - 2.00" DW FUEL PIPE - PREMIUM LINE
-  NUPI - 2.00" DW FUEL PIPE - DIESEL LINE
-  NUPI - 2.00" DW FUEL PIPE - DIESEL LINE
-  NUPI - 2.00" DW VENT PIPE - ALL LINES

PIPE SCHEDULE			
PIPE	USAGE	TYPE	APPROX. LINEAR FT.
2" DW UL LISTED FUEL PIPE	DEF	COIL	190'
2" DW UL LISTED FUEL PIPE	DIESEL	COIL	122'
2" DW UL LISTED FUEL PIPE	PREMIUM (BLUE)	COIL	537'
2" DW UL LISTED FUEL PIPE	PREMIUM (RED)	COIL	518'
2" DW UL LISTED FUEL PIPE	STANDARD	COIL	497'
2" DW UL LISTED VENT PIPE	VENT	STICK	512'

PIPE TOTALS	
COIL	1864'
STICK	512'

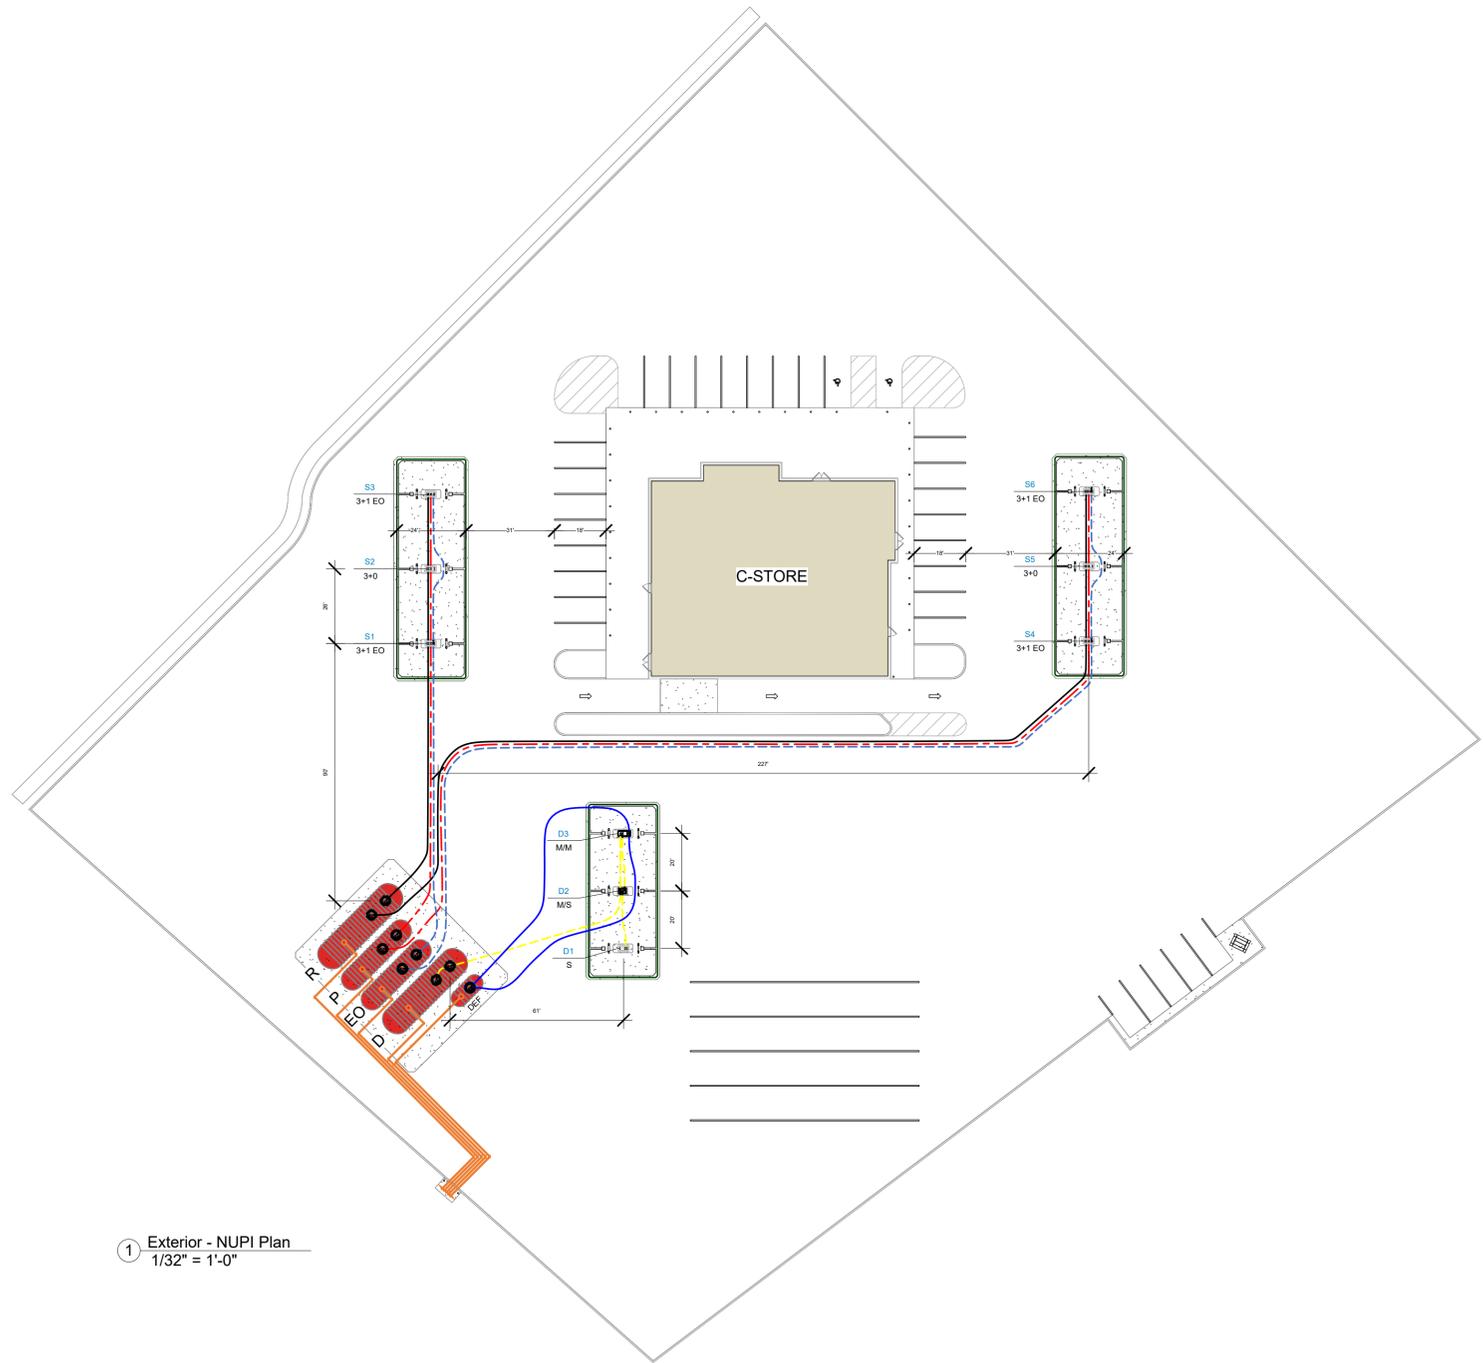

1 Exterior - NUPI Plan
1/32" = 1'-0"

EXTERIOR TANK DRAWING

ALL SIZES AND DIMENSIONS ARE APPROXIMATE. ACTUAL MAY VARY.



REV.	BY	DATE	DESCRIPTION

ANY SITE PLAN(S), FLOOR PLAN(S), RENDERING(S), LIGHTING LAYOUT(S) AND PHOTOMETRIC PLAN(S) INCLUDING BUT NOT LIMITED TO ANY PROJECT(S) CREATED/PRODUCED BY RED LEONARD ASSOCIATES INC. AND RLA TECHNOLOGIES SOLUTIONS INC. ARE ONLY INTENDED FOR ILLUSTRATION AND QUOTING PURPOSES ONLY. RED LEONARD ASSOCIATES INC. AND RLA TECHNOLOGIES SOLUTIONS INC. HAVE THE RIGHT TO USE THIRD PARTY LASERS, SCANNERS, AND CAMERAS BUT ACTUAL PROJECT CONDITIONS, DIMENSIONS, AND ACCURACY OF MEASUREMENTS MAY DIFFER FROM THESE OR ANY PARAMETERS. RED LEONARD ASSOCIATES INC. AND RLA TECHNOLOGIES SOLUTIONS INC. ASSUMES NO LIABILITY FOR WHAT IS CREATED/PRODUCED IN THESE RECREATIONS. THIS INCLUDES BUT IS NOT LIMITED TO THE USE OF, INSTALLATION OF AND/OR INTEGRITY OF EXISTING BUILDING(S), SURROUNDING AREA FOR PRODUCT(S) SUCH AS EXISTING POLE(S), ANCHOR BOLT(S), BASE(S), ARCHITECTURAL AND SIGNAGE STRUCTURE(S), LANDSCAPING PLAN(S), LIGHTING PLAN(S), FIXTURE SELECTION(S) AND PLACEMENT, MATERIAL(S), COLOR ACCURACY, TEXTURE(S), AND ANYTHING ATTRIBUTED TO PHOTO REALISM THAT IS CREATED. FURTHERMORE, RED LEONARD ASSOCIATES INC. AND RLA TECHNOLOGIES SOLUTIONS INC. DOES NOT ASSUME LIABILITY WHATSOEVER FOR ANY PURCHASES MADE BY CLIENT BEFORE, DURING, OR AT THE CONCLUSION OF THE PUBLISHED WORK. THE CUSTOMER, ITS RELATIVE AFFILIATES, AS WELL AS ANY OTHER PERSON(S) IN VIEWING OF THIS PRODUCT IS RESPONSIBLE FOR VERIFYING COMPLIANCE WITH ANY BUT NOT LIMITED TO ALL CODES, PERMITS, RESTRICTIONS, INSTRUCTIONS, PURCHASES, AND INSTALLATIONS OF OBJECTS VIEWED WITHIN THIS DOCUMENT(S) OR PROJECT(S). SYMBOLS ARE NOT DRAWN TO SCALE. SIZE IS FOR CLARITY PURPOSES ONLY. SIZES AND DIMENSIONS ARE APPROXIMATE. ACTUAL MEASUREMENTS MAY VARY. DRAWINGS ARE NOT INTENDED FOR ENGINEERING OR CONSTRUCTION USE. THIS DOCUMENT, ANY DRAWING(S), OR PROJECT(S) IS NOT TO BE USED AND/OR INTENDED FOR ENGINEERING OR CONSTRUCTION PURPOSES, BUT FOR ILLUSTRATIVE PURPOSES ONLY. ANY USE OF THIS DOCUMENTATION AND/OR OTHER ARTICLES PRODUCED BY RED LEONARD ASSOCIATES INC. AND RLA TECHNOLOGIES SOLUTIONS INC., WITHOUT WRITTEN AUTHORIZATION FROM JAYME J. LEONARD IS STRICTLY PROHIBITED.

PROJECT NAME:	
LAYOUT BY:	RED LEONARD ASSOCIATES, INC.
MW, JHB	1340 KEMPER MEADOW DR FOREST PARK, OH 45240
DATE:	10/16/25
10/16/25	DRAWING NUMBER:
	SAMPLE_0001